





RESTROOM NORTH

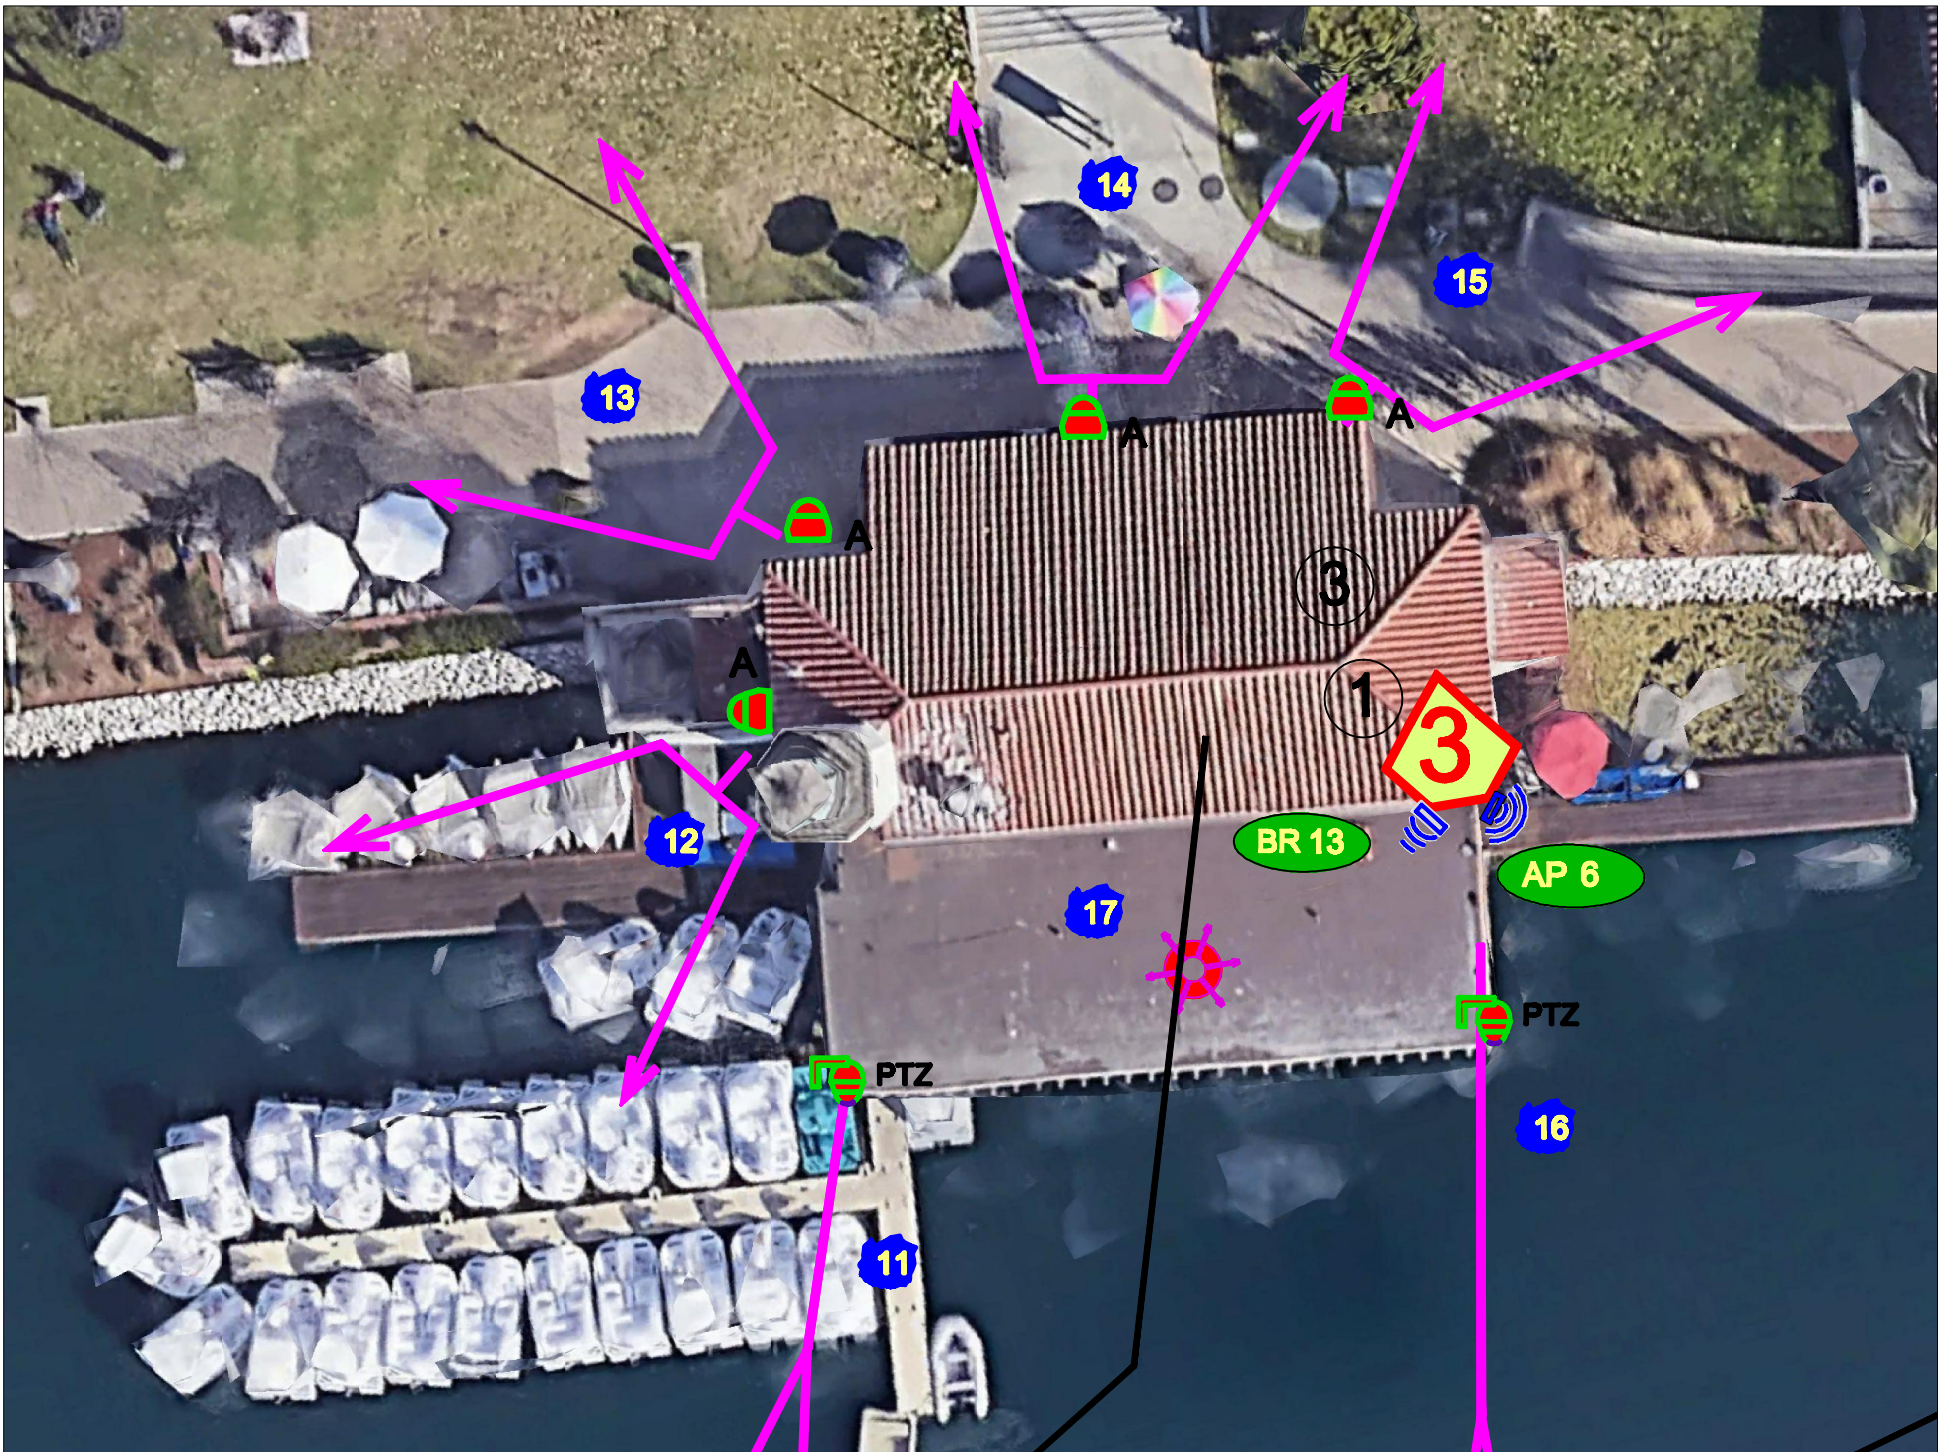


BOAT HOUSE BUILDING

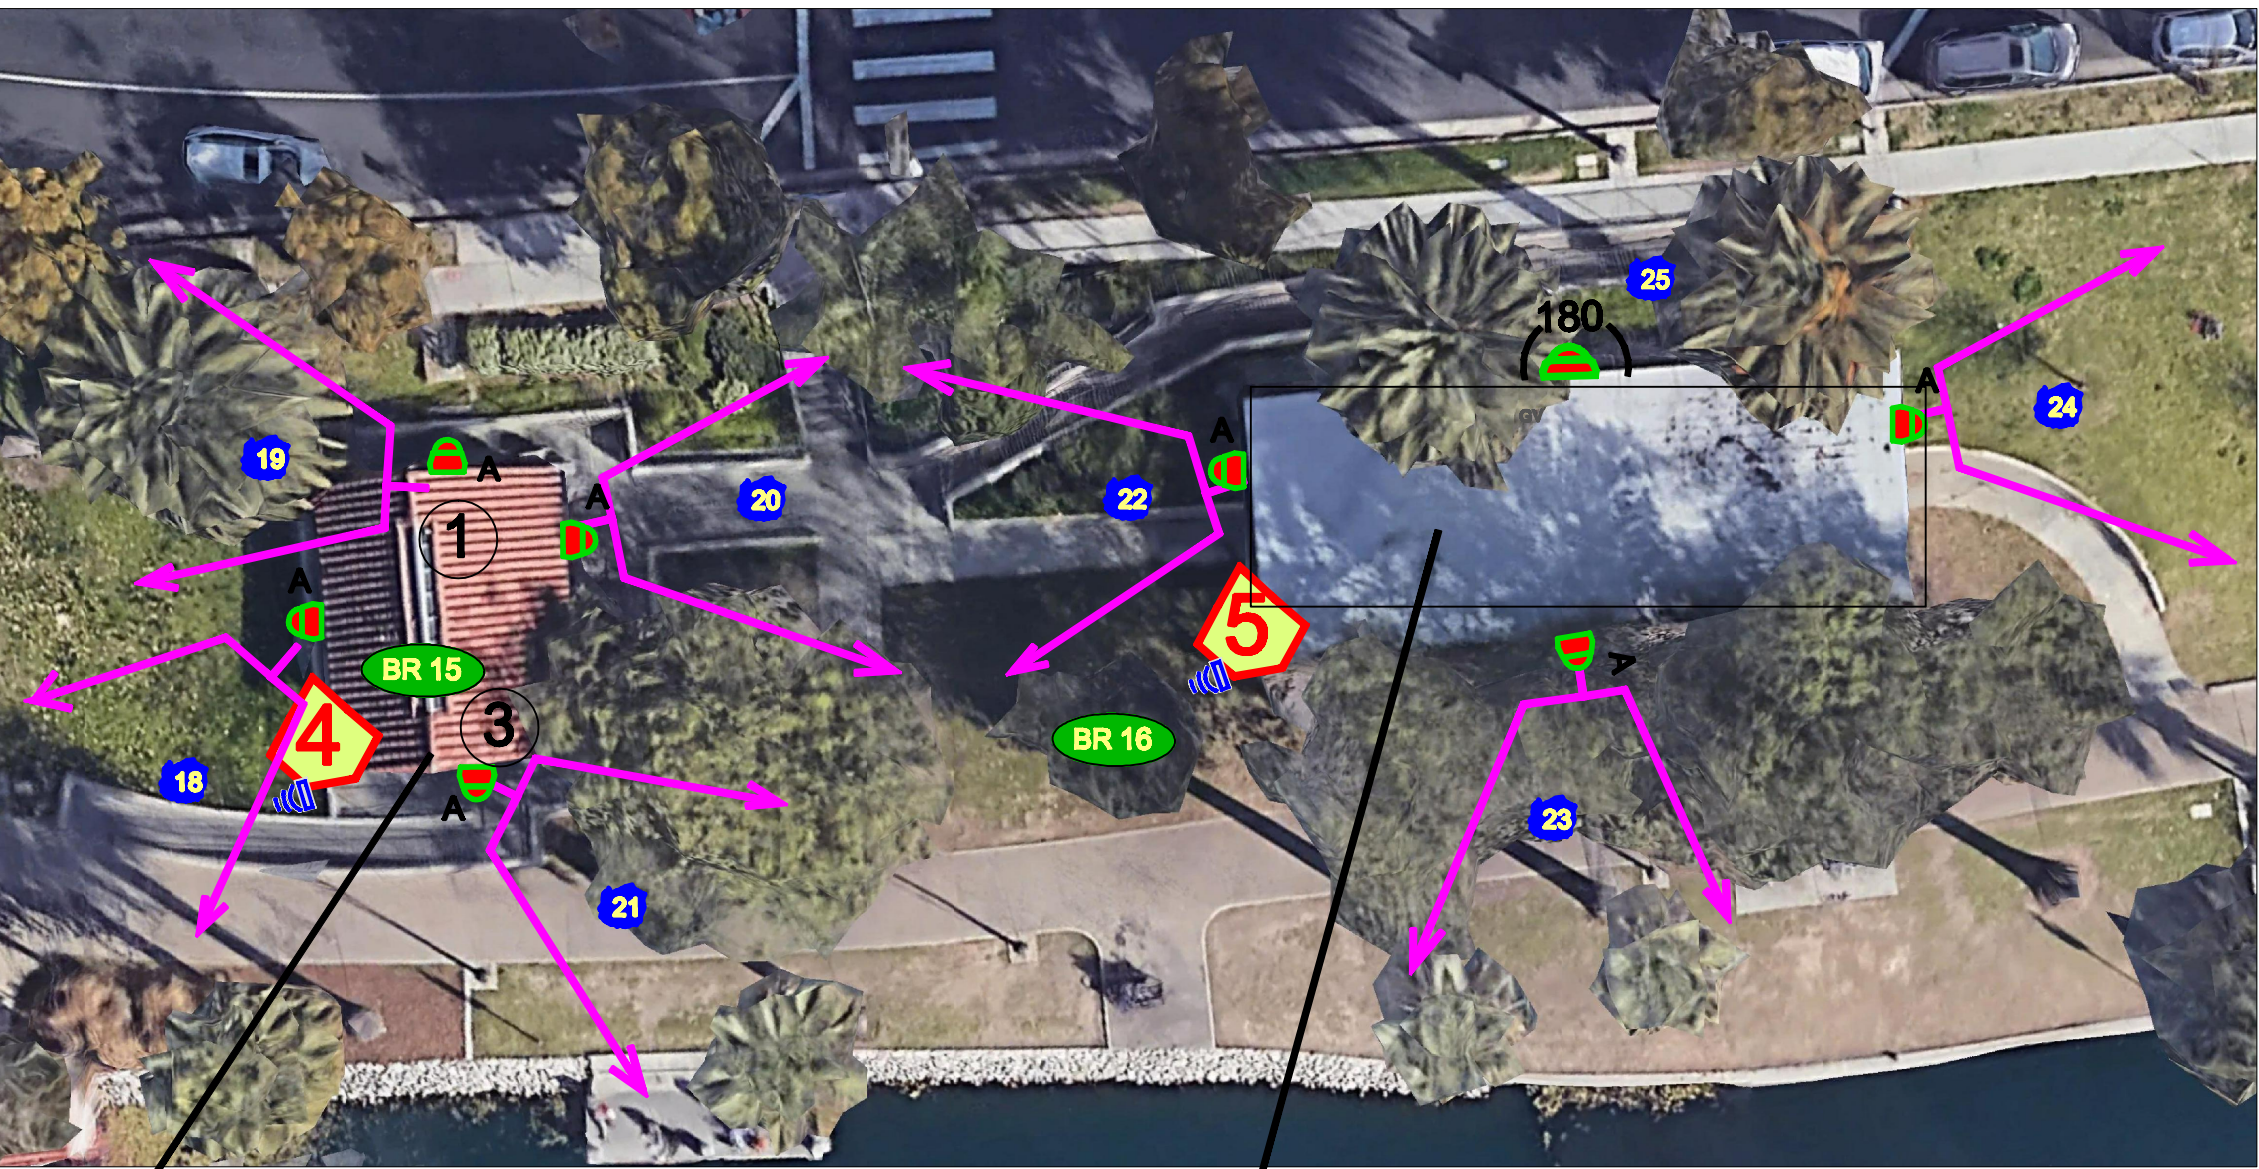


RESTROOM CENTER

WORK CENTER BUILDING

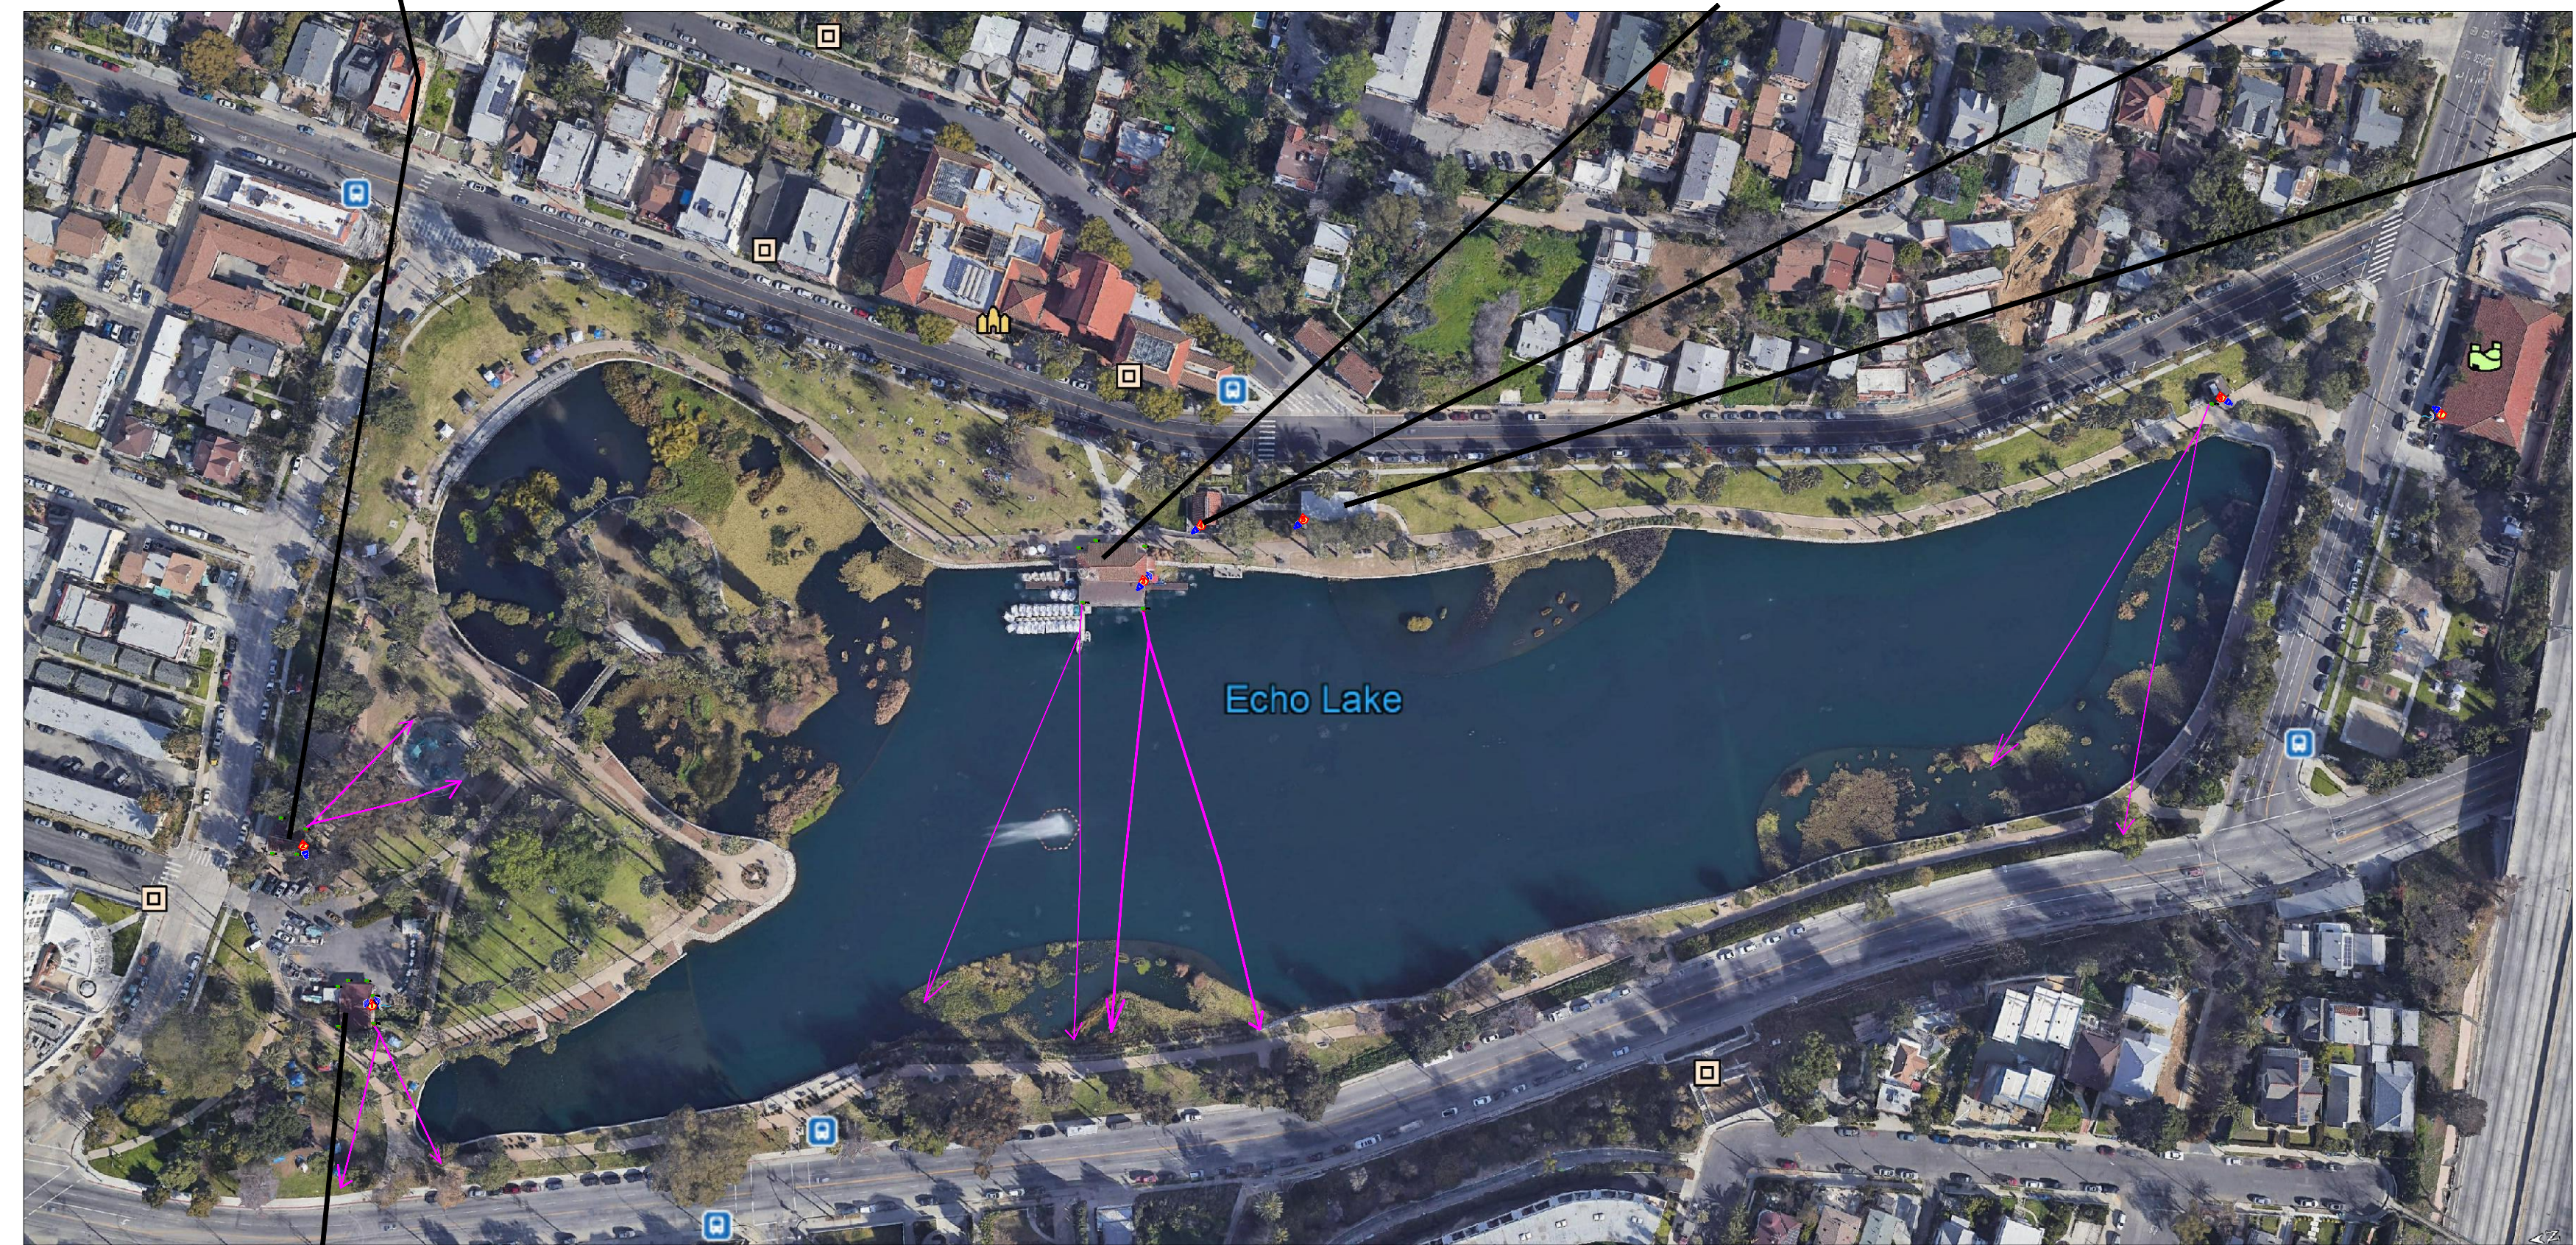

Echo Lake

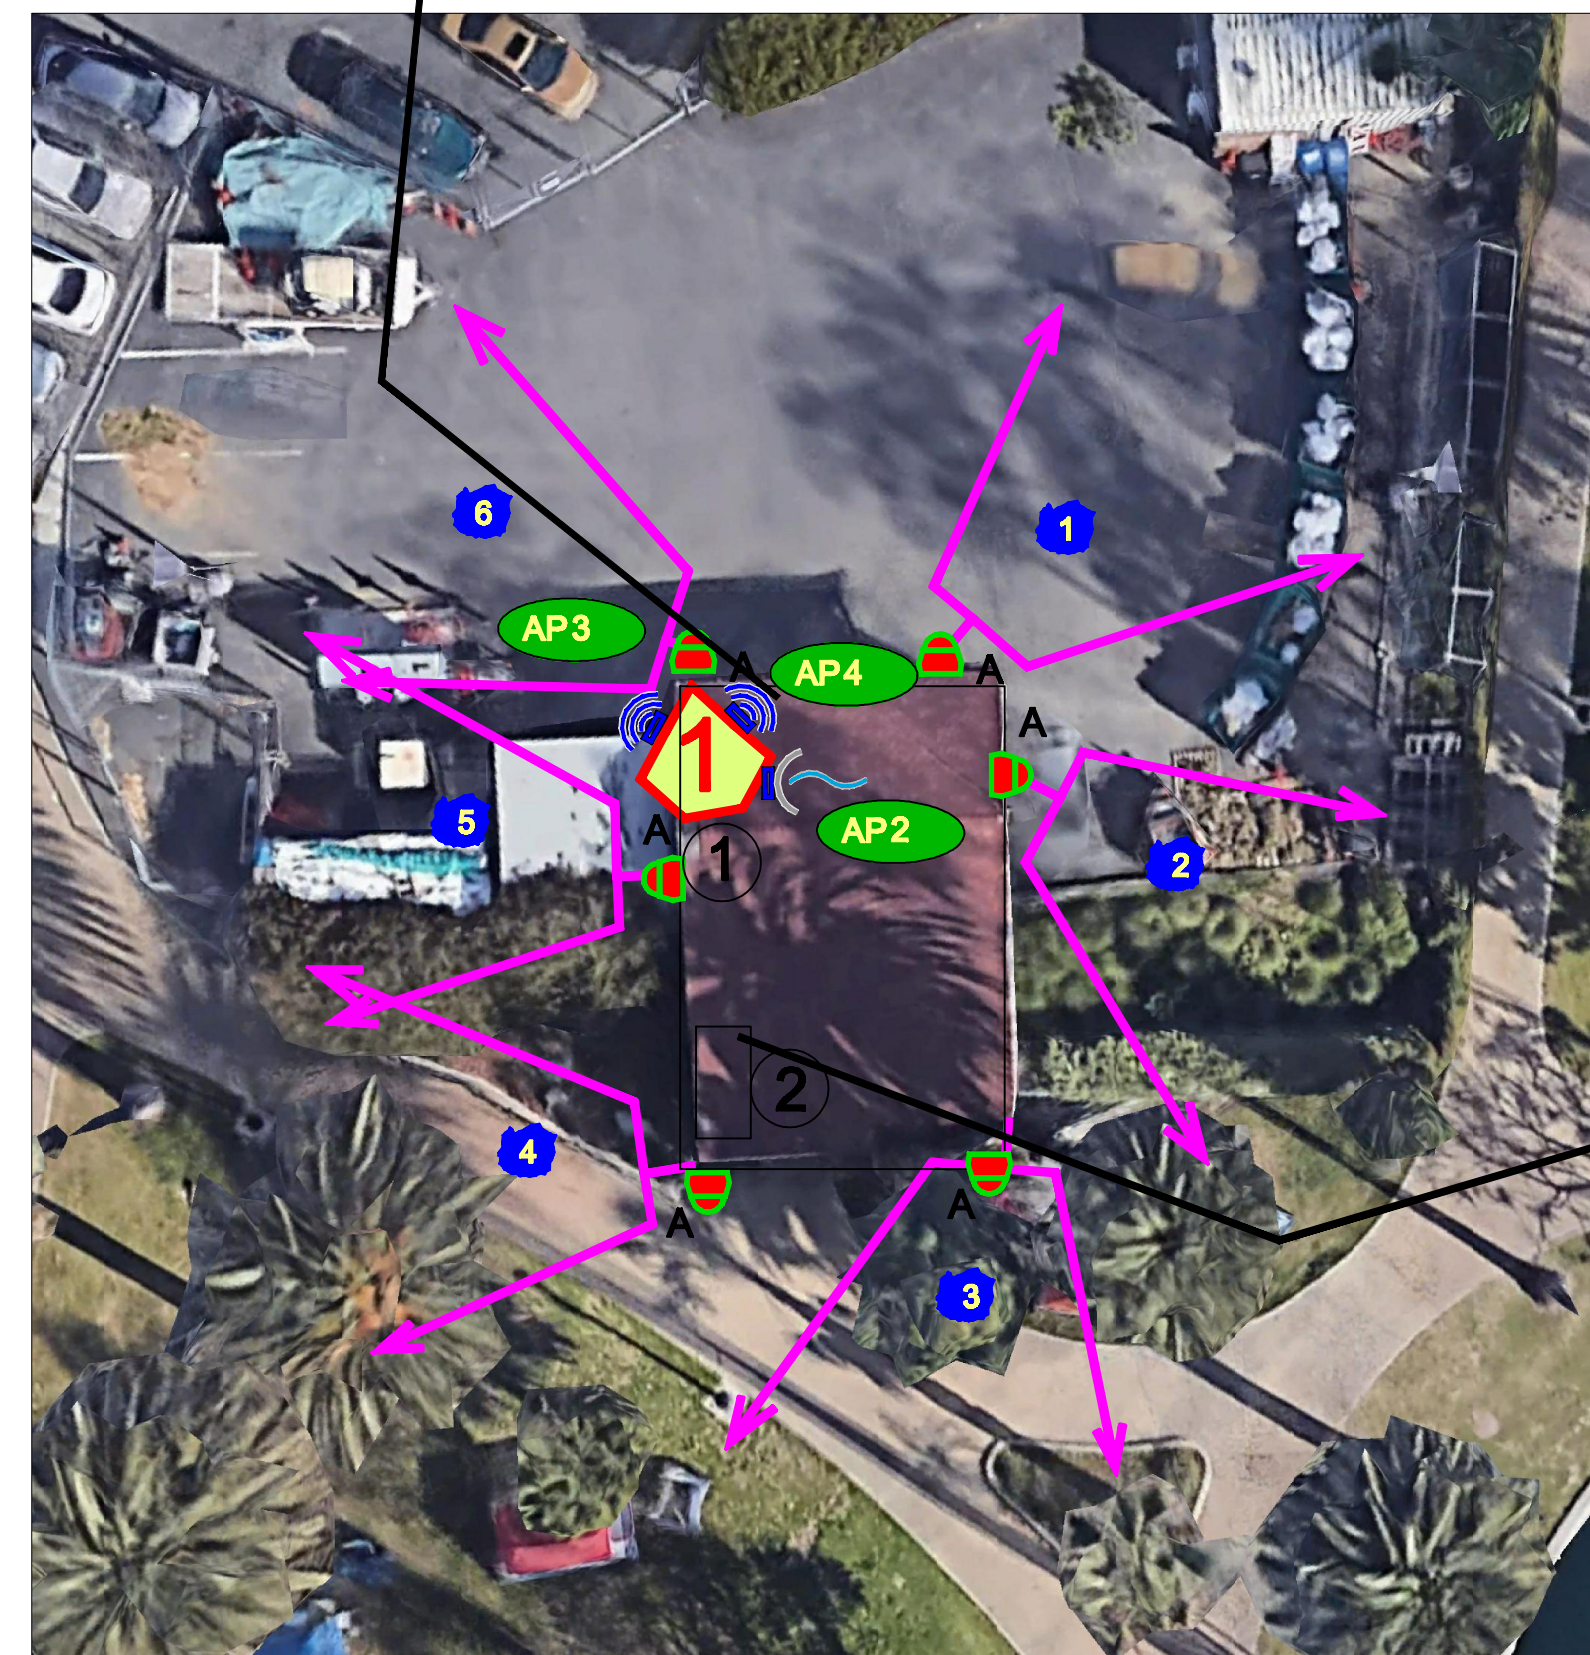


MAINTENANCE BUILDING

1 SITE CCTV PLAN
SCALE: NONE



NVR RACK LOCATION

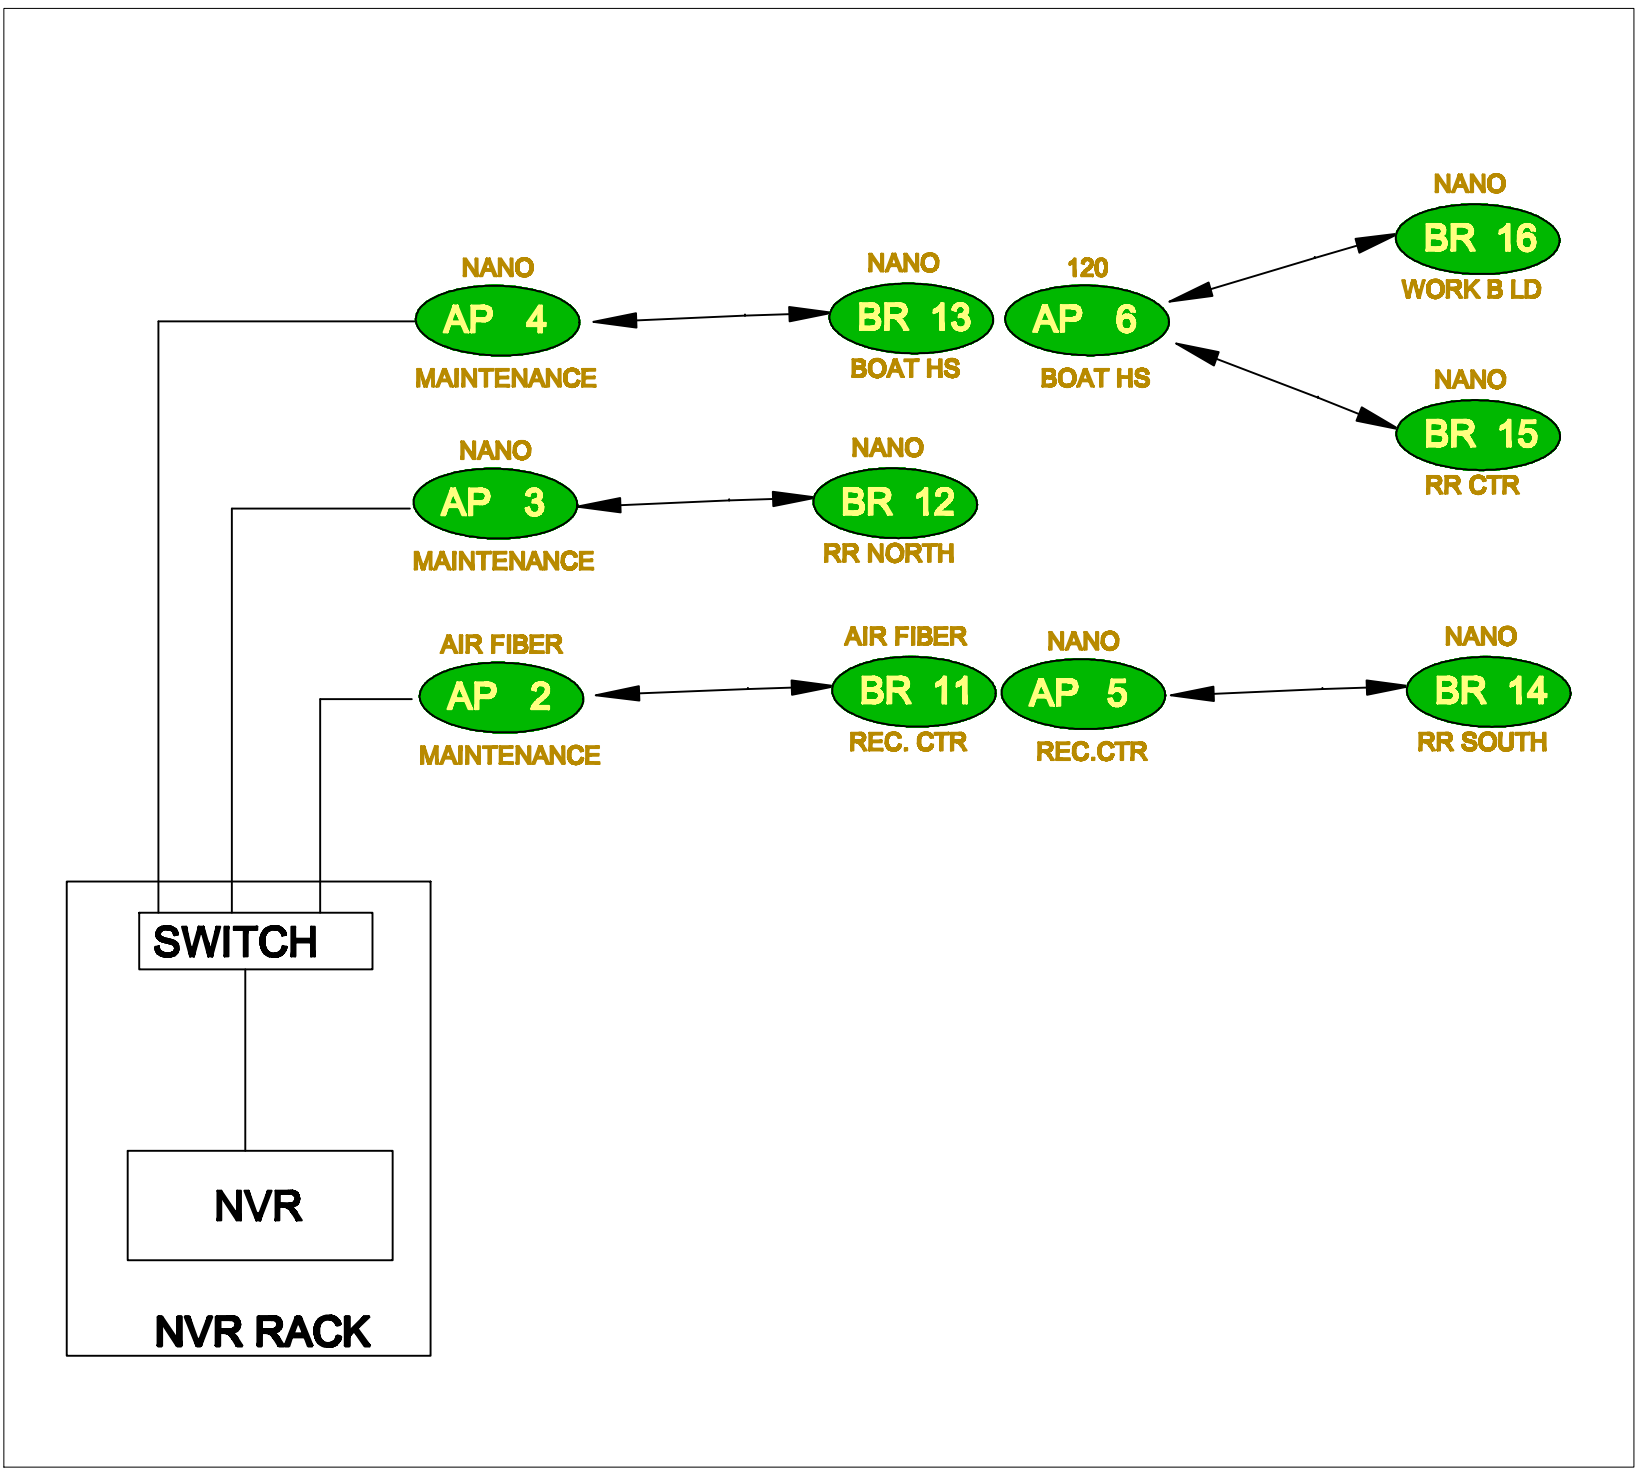

WIRELESS AP FLOW CHART

- CCTV SITE PLAN NOTES:
- 1 FOR ANTENNA MOUNTING SEE DETAIL #8 SHEET E-2593A - D1.
 - 2 NVR IN WALL CABINET. BACKBOX INSTALLED BY ELECTRICAL CONTRACTOR. 120V POWER REQUIRED. SEE DETAILS #1, #2, & #3 SHEET E-2598A-D1
 - 3 EQUIPMENT CABINET ON OR IN BUILDING (120V AC REQUIRED). CANTEX BOX 18"X18"X 6" BY ELECTRICAL CONTRACTOR. MOUNTING LOCATIONS TO BE DETERMINED. SEE DETAILS #7 SHEET E-2598A - D1
 - 4 CAMERA MOUNTING ON OUTSIDE OF BUILDING SEE DETAILS #11 SHEET E-2598A - D1
 - 5 ELECTRICAL CONTRACTOR TO PROVIDE PULL STRING IN ALL CONDUIT.
 - 6 ALL LOCATIONS TO BE VERIFIED BEFORE INSTALLATION

CAMERA AND AP INFORMATION			QTY
GV-TVD4710	DOME CAMERA VANDAL PROOF	A	30
GV-SD2722-IR	PTZ VANDAL PROOF 5M CAMERA	PTZ	3
M3058-PVE	FISH EYE AXIS 12 MP 360	180	5
P3807-PVE	180 DEGREE AXIS	D	3
NBE-5AC-19	WIRELESS LINK UBIQUITI		6
LAP-GPS	WIRELESS LINK 120 DEGREES UBIQUITI		2
AFGD-US	WIRELESS LINK AIR FIBER UBIQUITI		2

CAMERA NUMBER

AP # = AP NUMBER
2 THRU 10 ACCESS POINT

BR # = BRIDGE NUMBER
11 THRU 90 WIRELESS BRIDGE








1520 W. 178th Street
Gardena, Ca 90248
Phone (310) 756-6610
Fax (888) 251-1218
State License No. 986306

PROJECT NAME:
ECHO PARK (LAKE)
751 ECHO PARK AVE
LOS ANGELES, CA. 90026

SHEET TITLE:
CAMERA SYSTEM LAYOUT
LAKE ARE

PAGE 1 OF 3




DESIGNED BY A.N., E.G.	APPROVED BY	JOB NO. J —	DATE: 5/5/2021
DRAWN BY A. NIE	APPROVED BY	SCALE:	
CHECKED BY ED	APPROVED BY	DRAWING NO. E-2598A-S1	REV. NO.
SUPERVISOR JOHN	APPROVED BY CONNER		

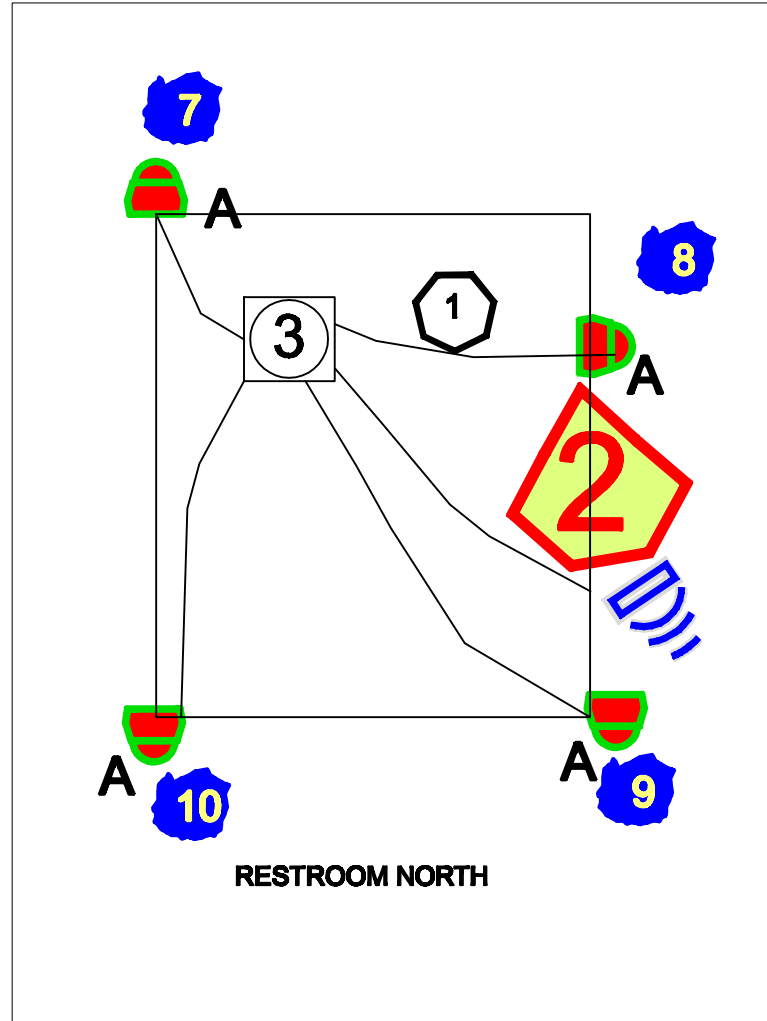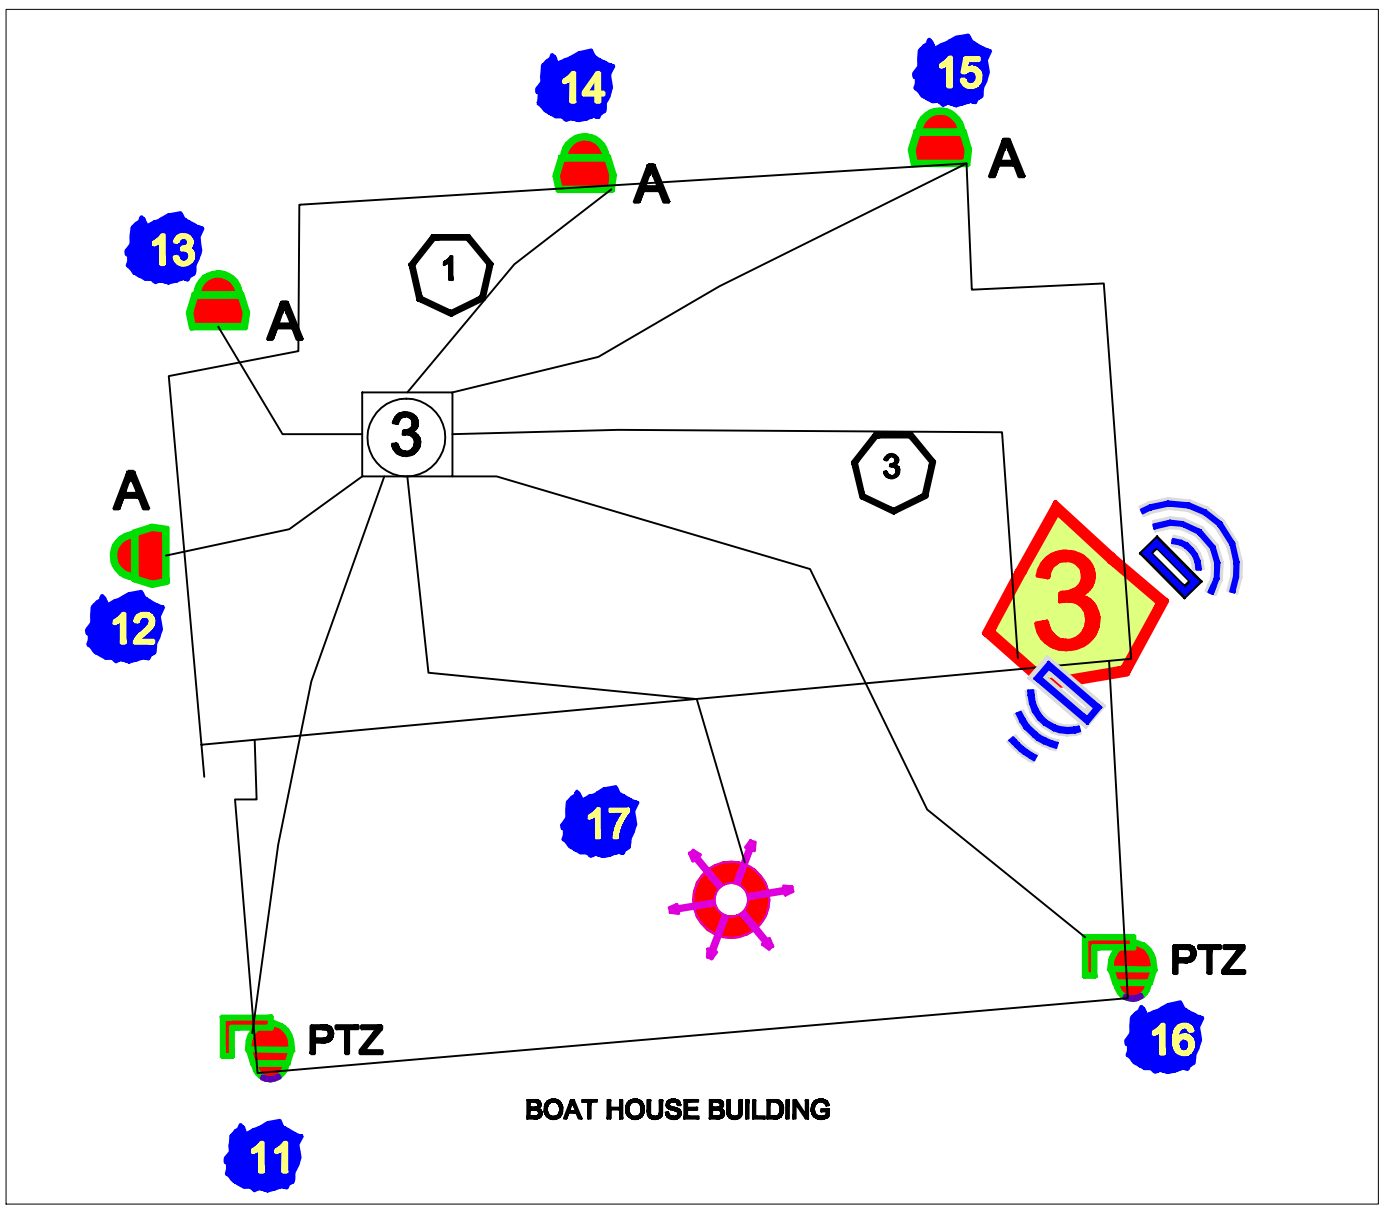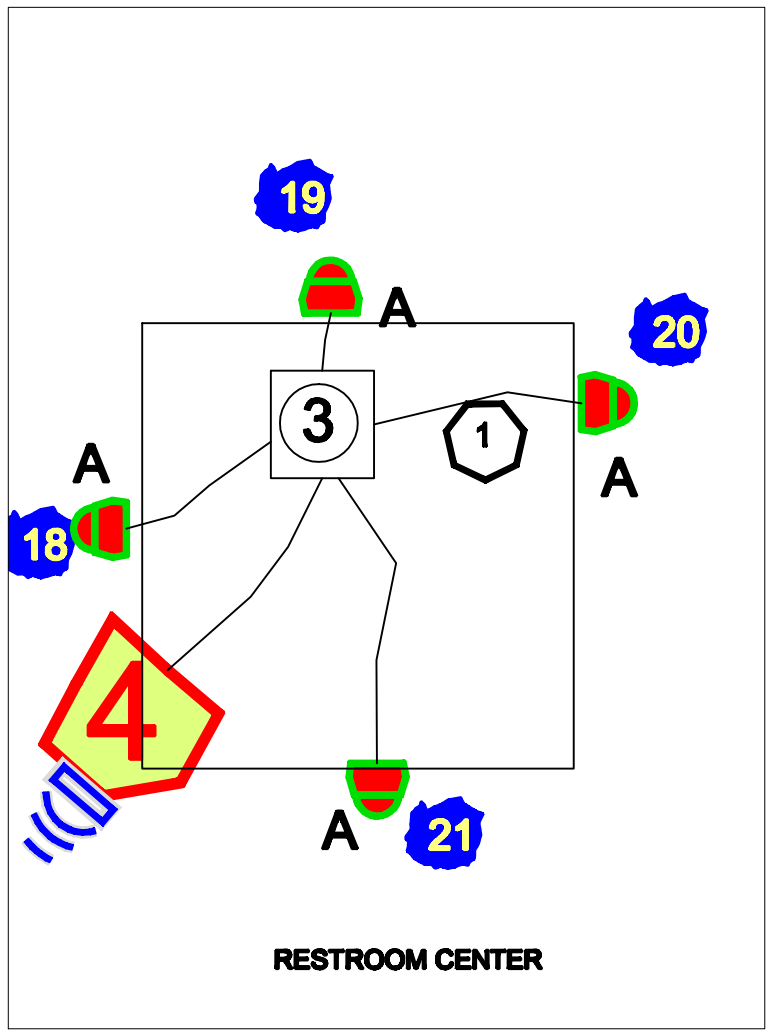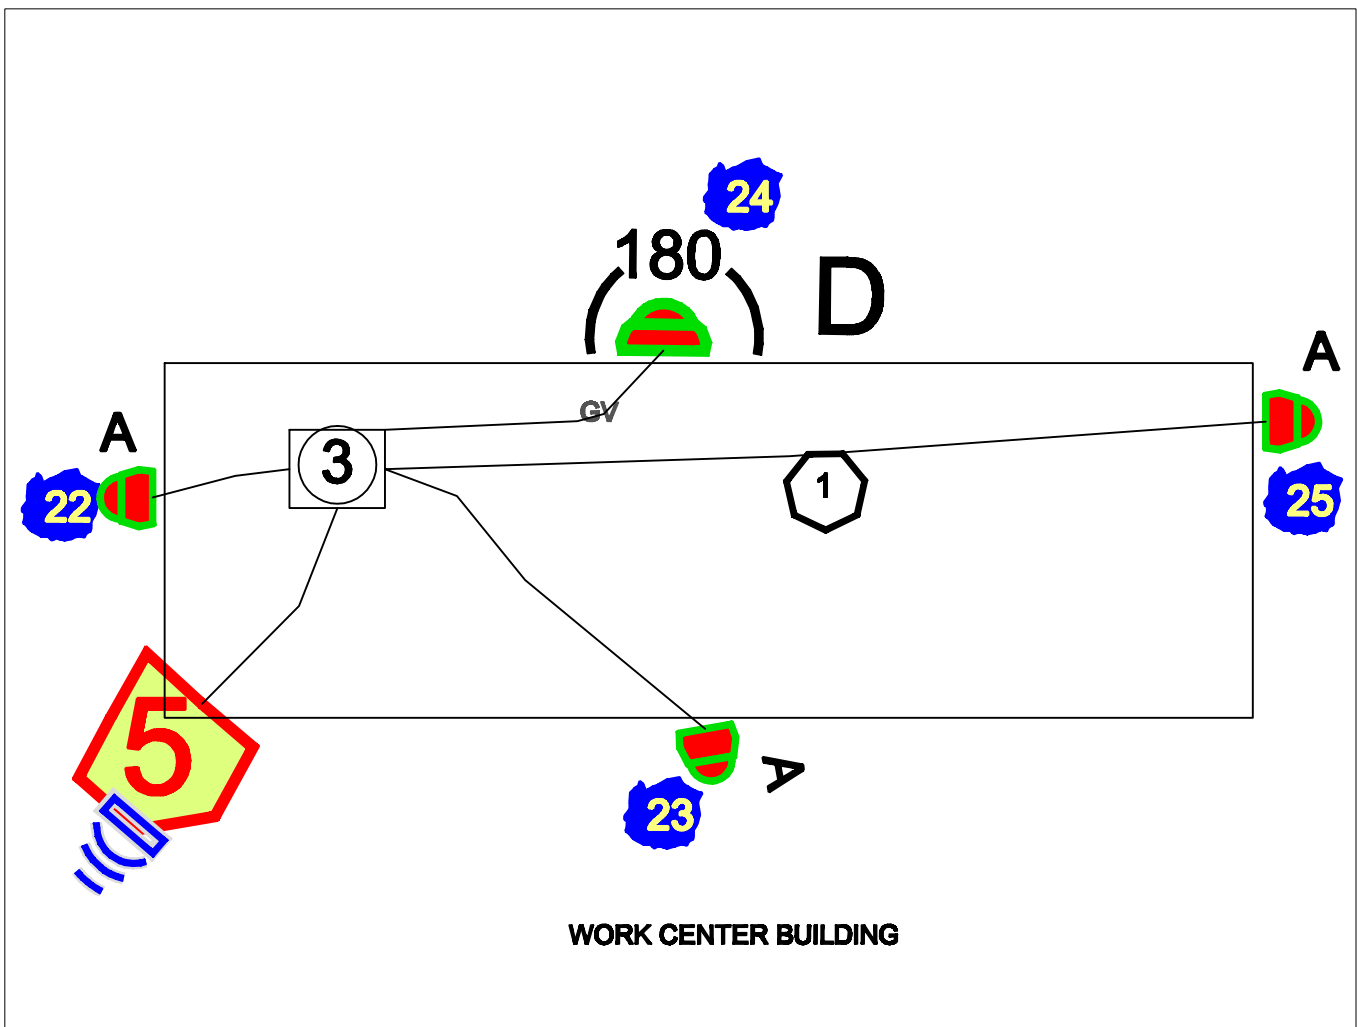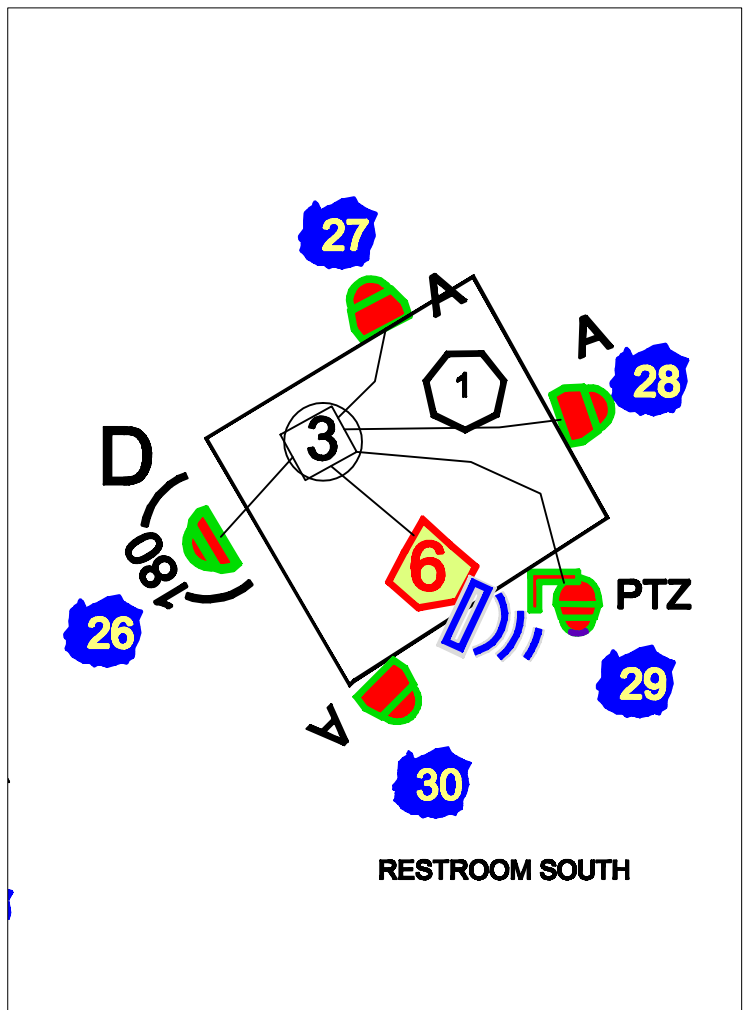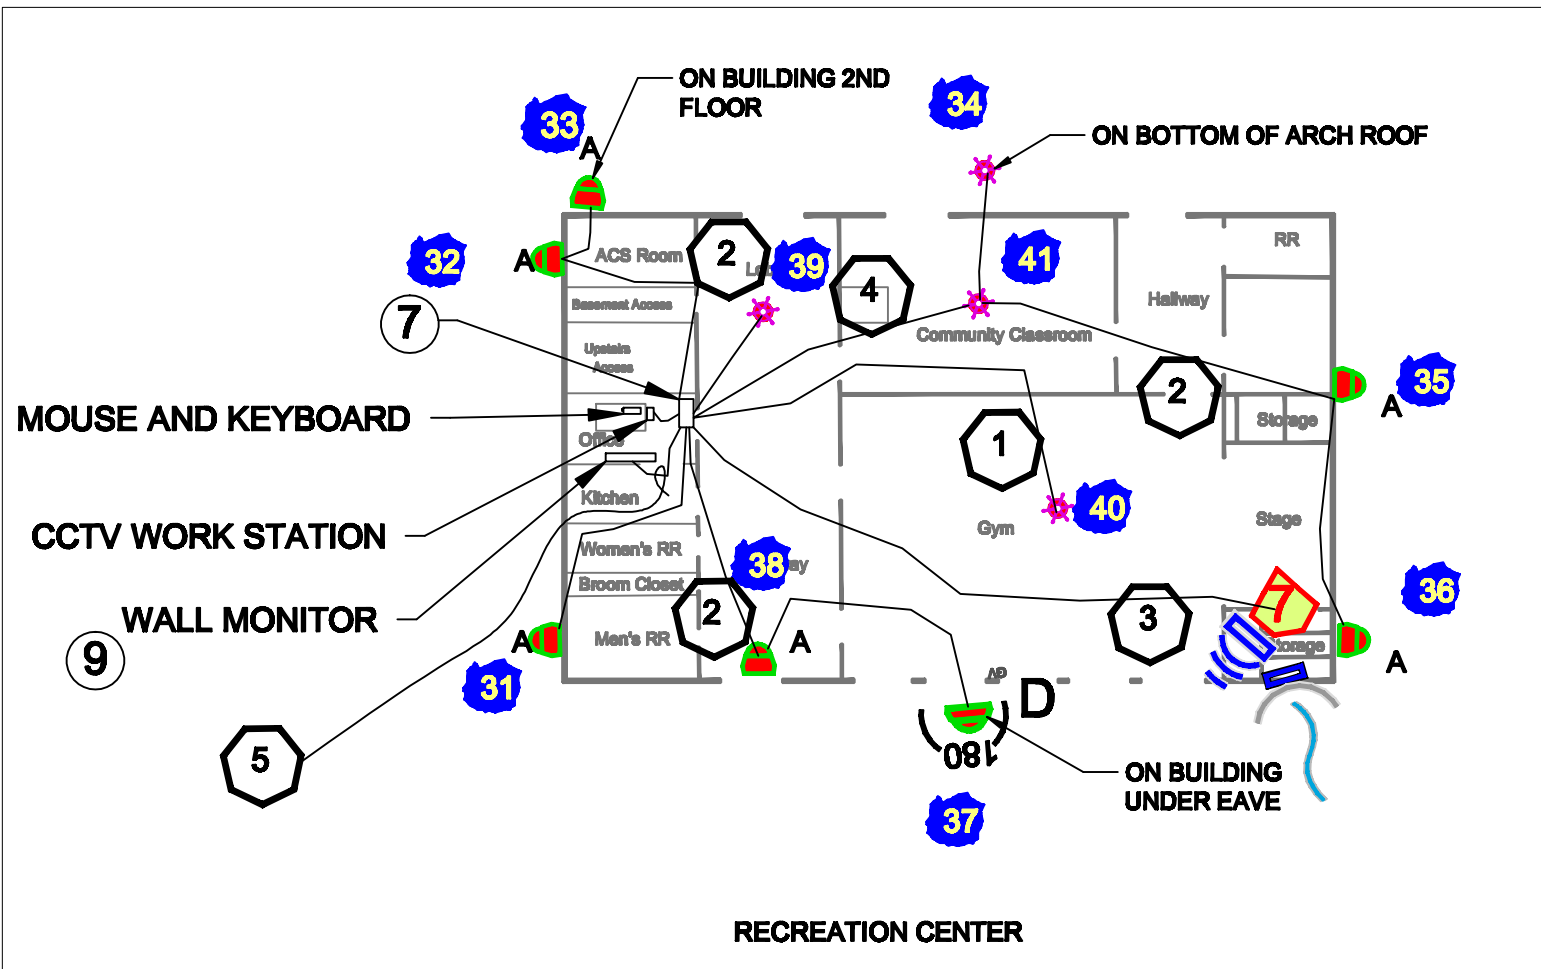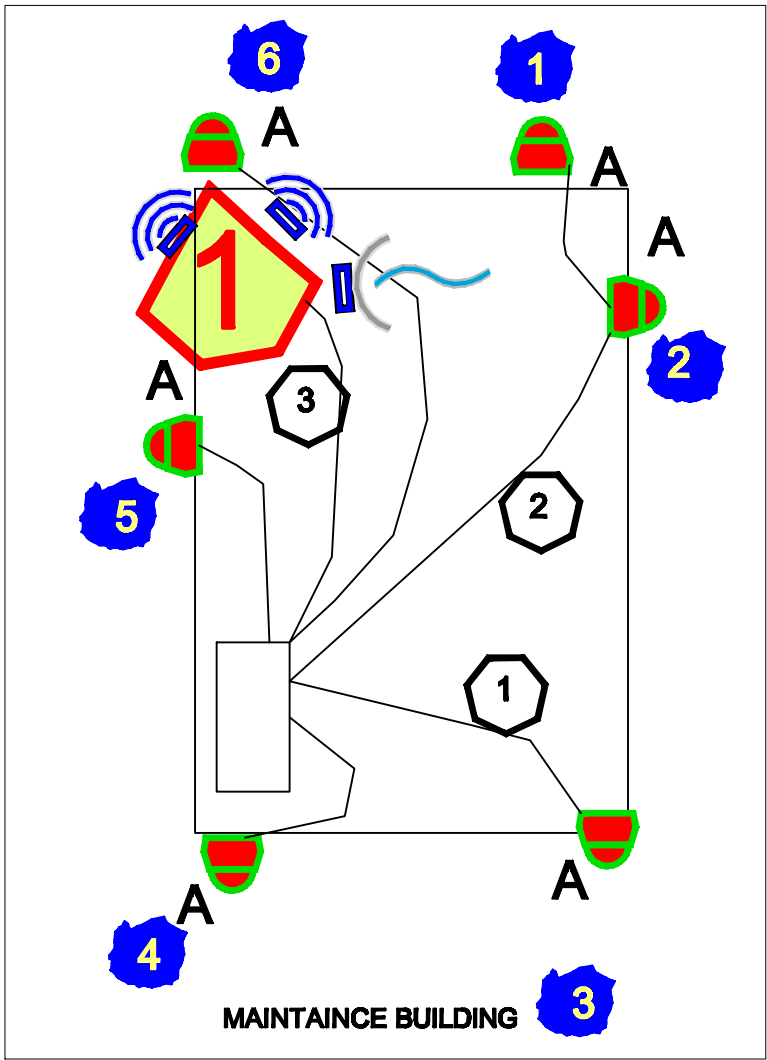

CCTV WIRE NOTES:

- 3/4" CONDUIT WITH (1) CAT6 CABLE TYPICAL
- 3/4" CONDUIT WITH (2) CAT6 CABLE
- 1" CONDUIT WITH (3) CAT6 CABLE
- 1" CONDUIT WITH (4) CAT6 CABLE
- 1 1/4" CONDUIT WITH (1) HDMI CABLE

CAMERA AND AP INFORMATION			QTY
GV-TVD4710	DOME CAMERA VANDAL PROOF	A	30
GV-SD2722-IR	PTZ VANDAL PROOF 5M CAMERA	PTZ	3
M3058-PVE	FISH EYE AXIS 12 MP 360		5
P3807-PVE	180 DEGREE AXIS	D	3
NBE-5AC-19	WIRELESS LINK UBIQUITI		6
LAP-GPS	WIRELESS LINK 120 DEGREES UBIQUITI		2
AFGD-US	WIRELESS LINK AIR FIBER UBIQUITI		2

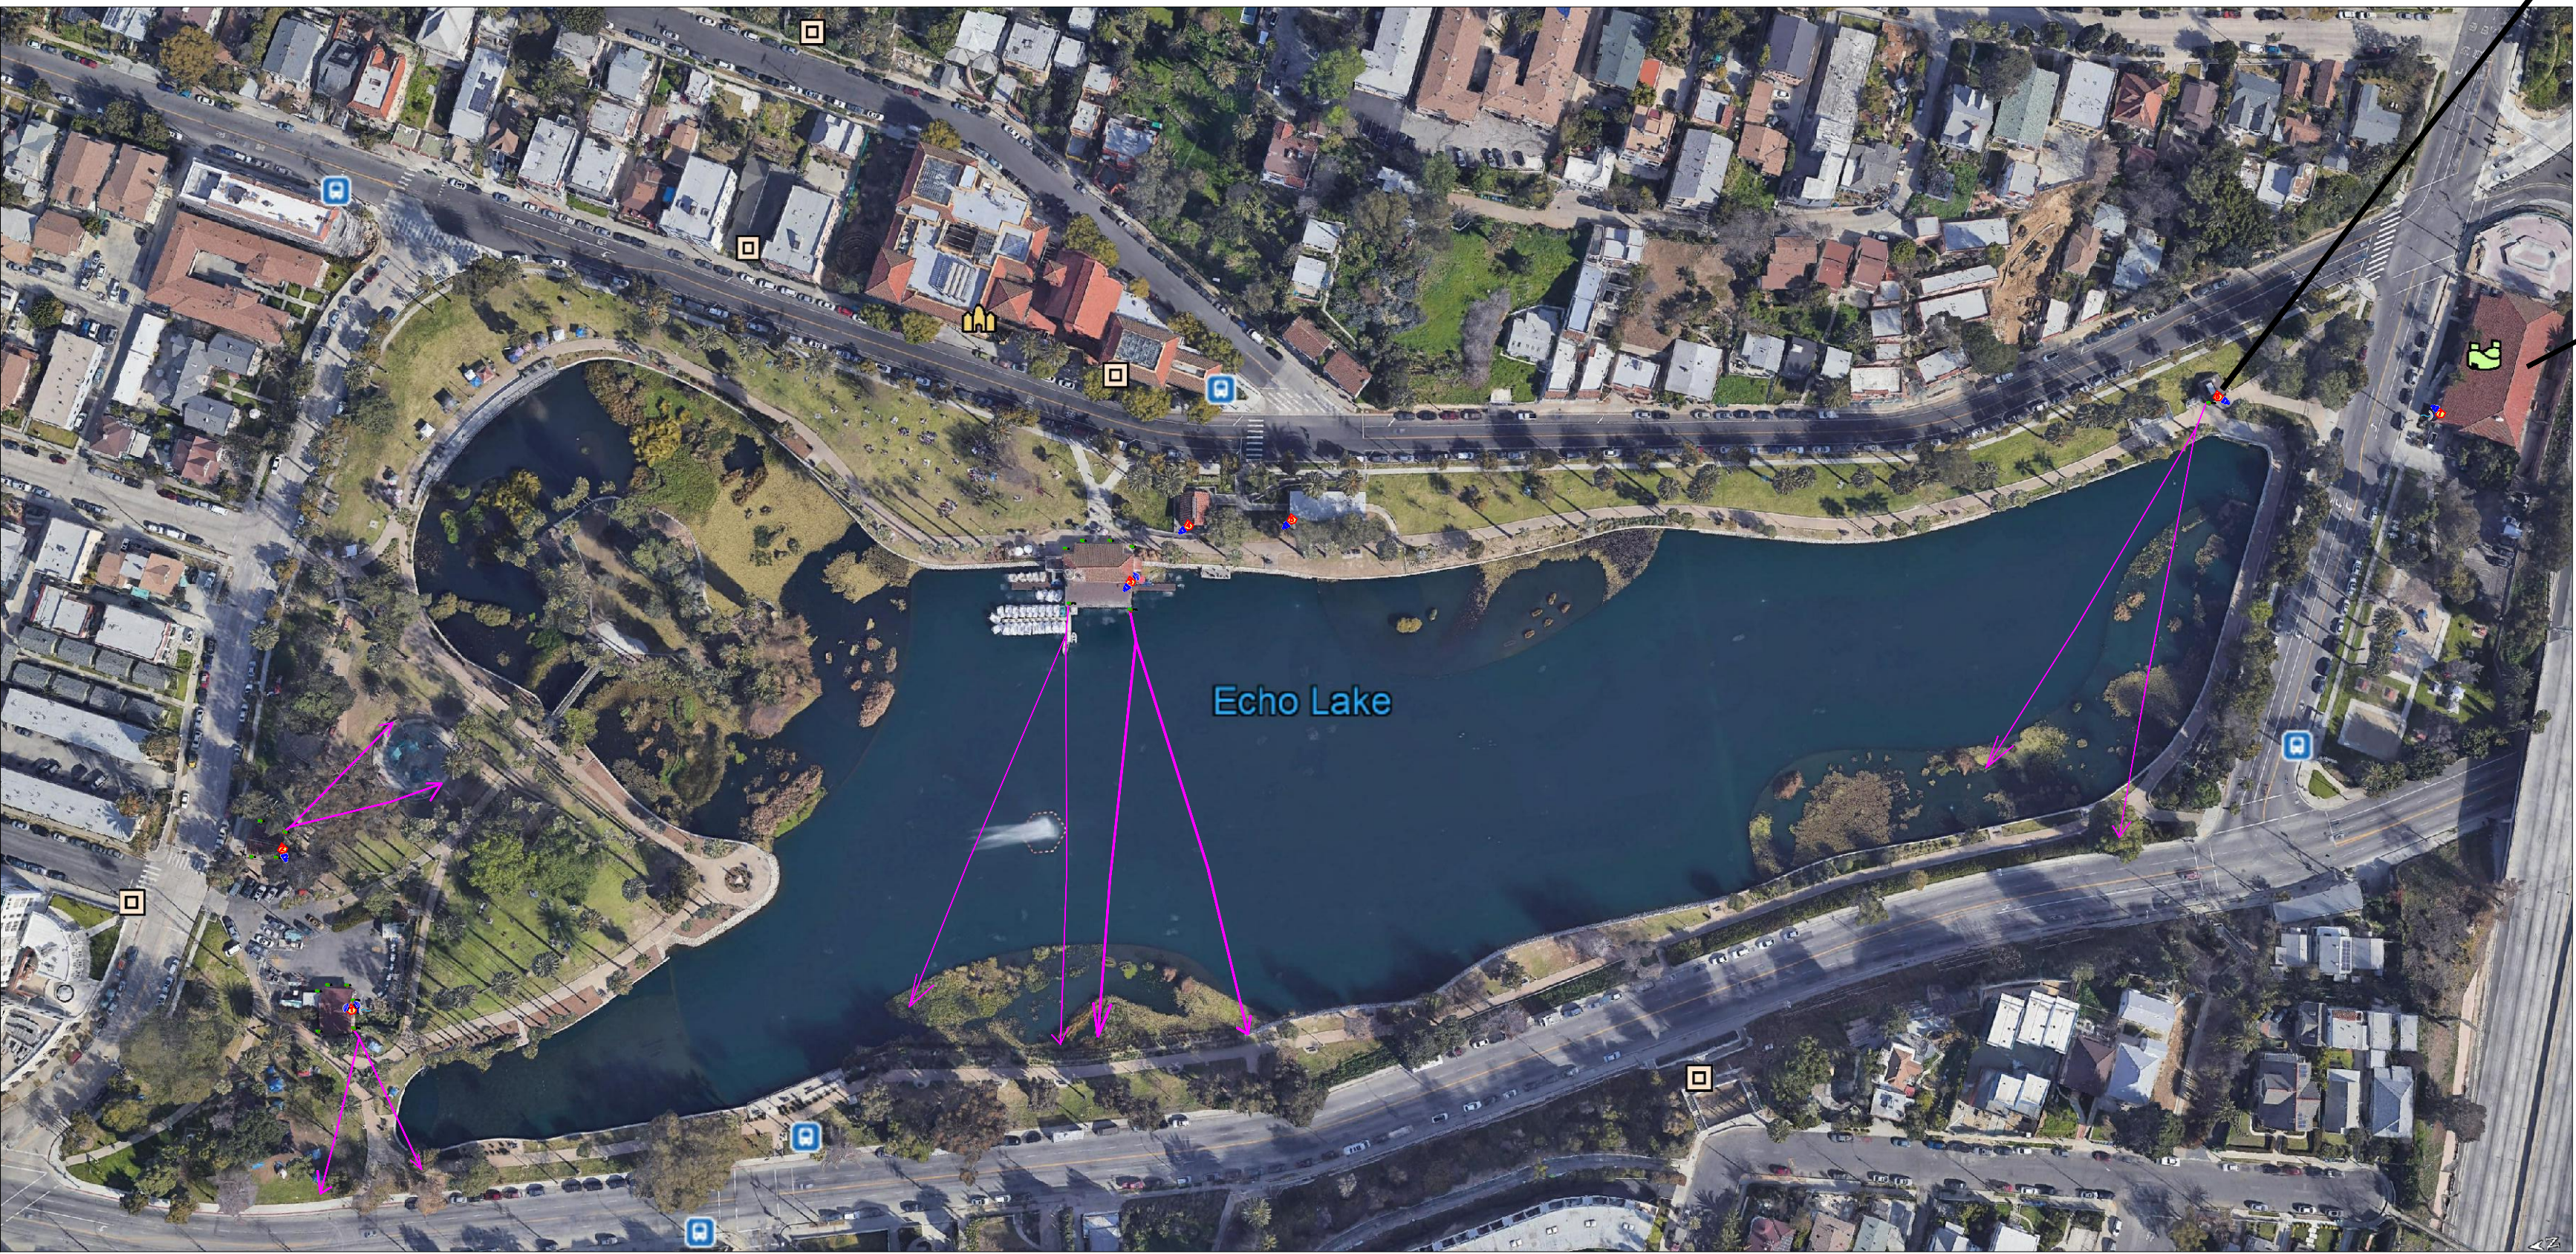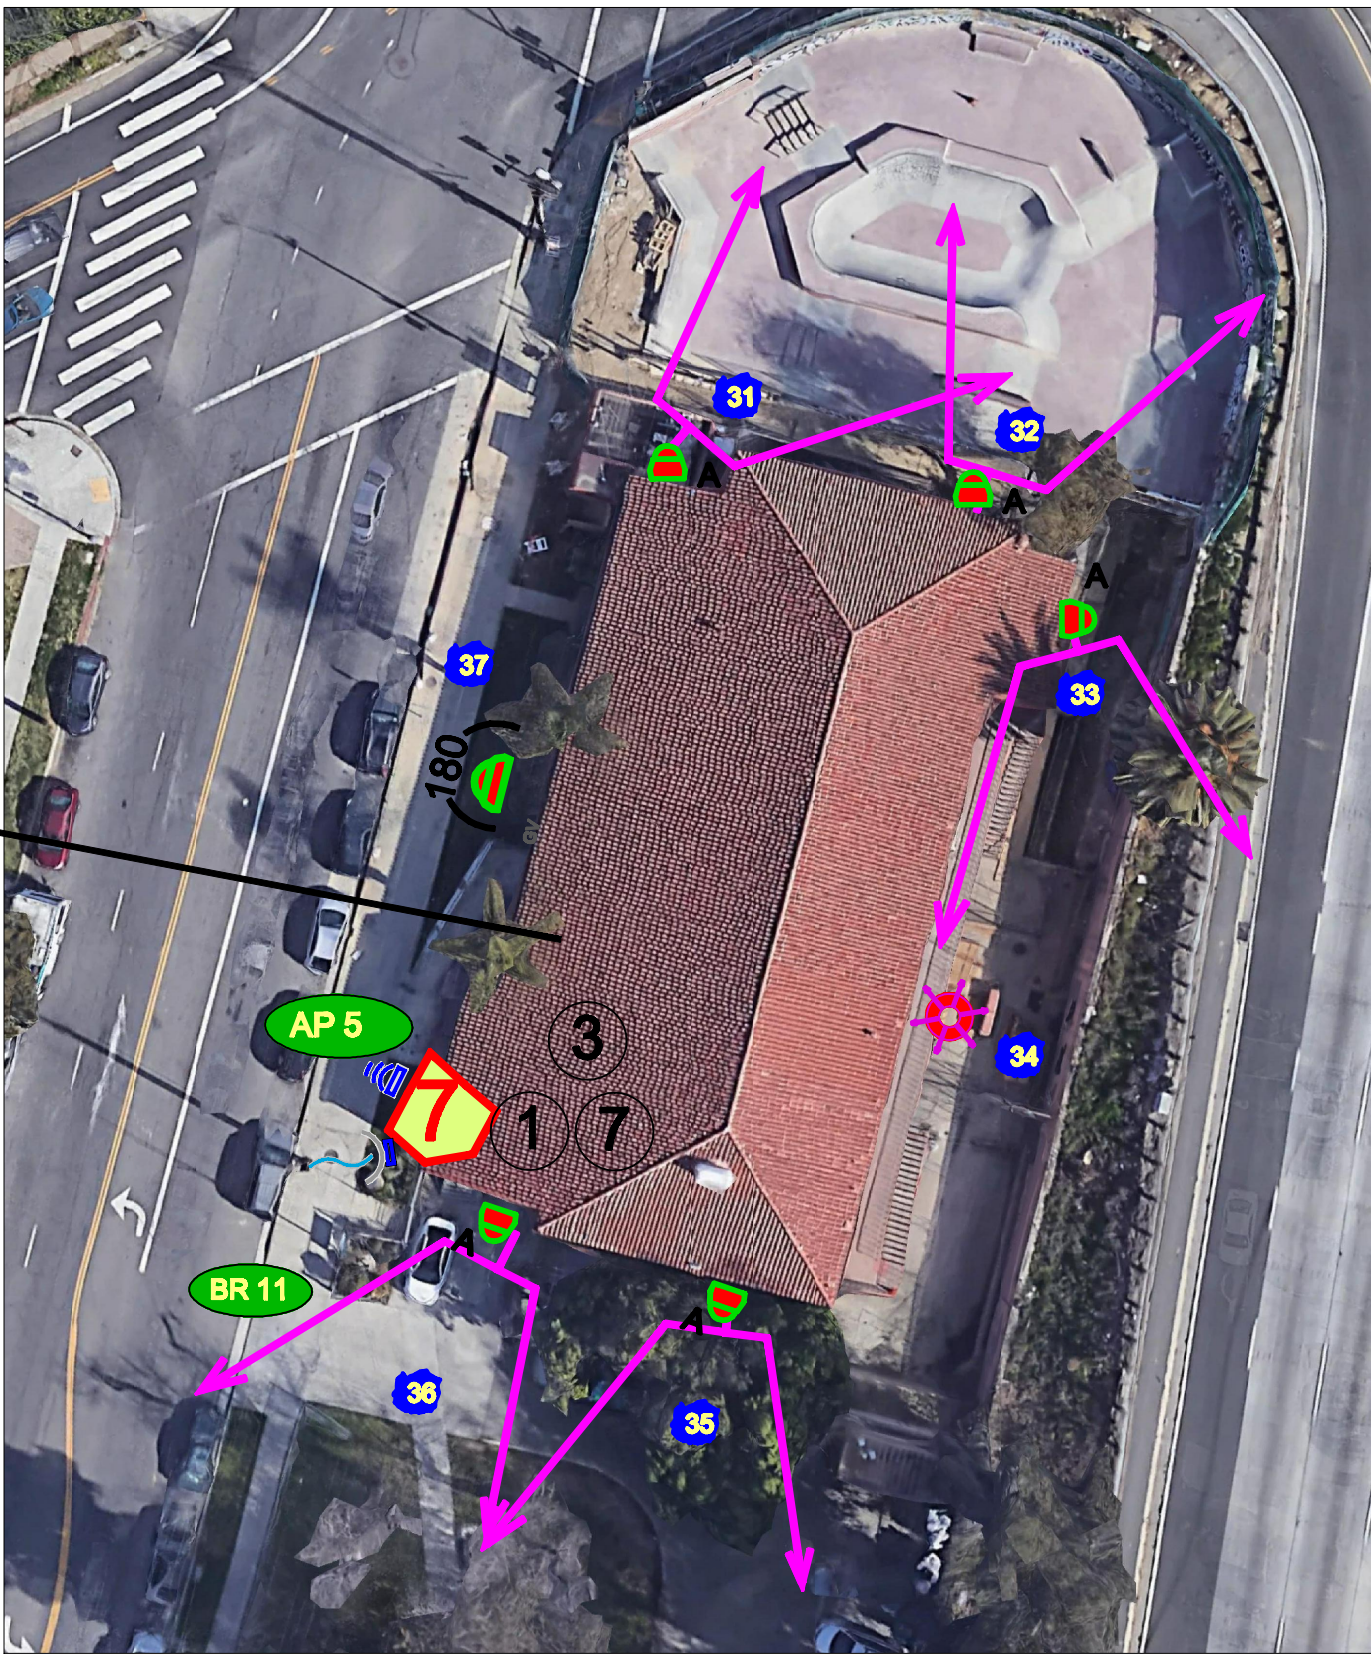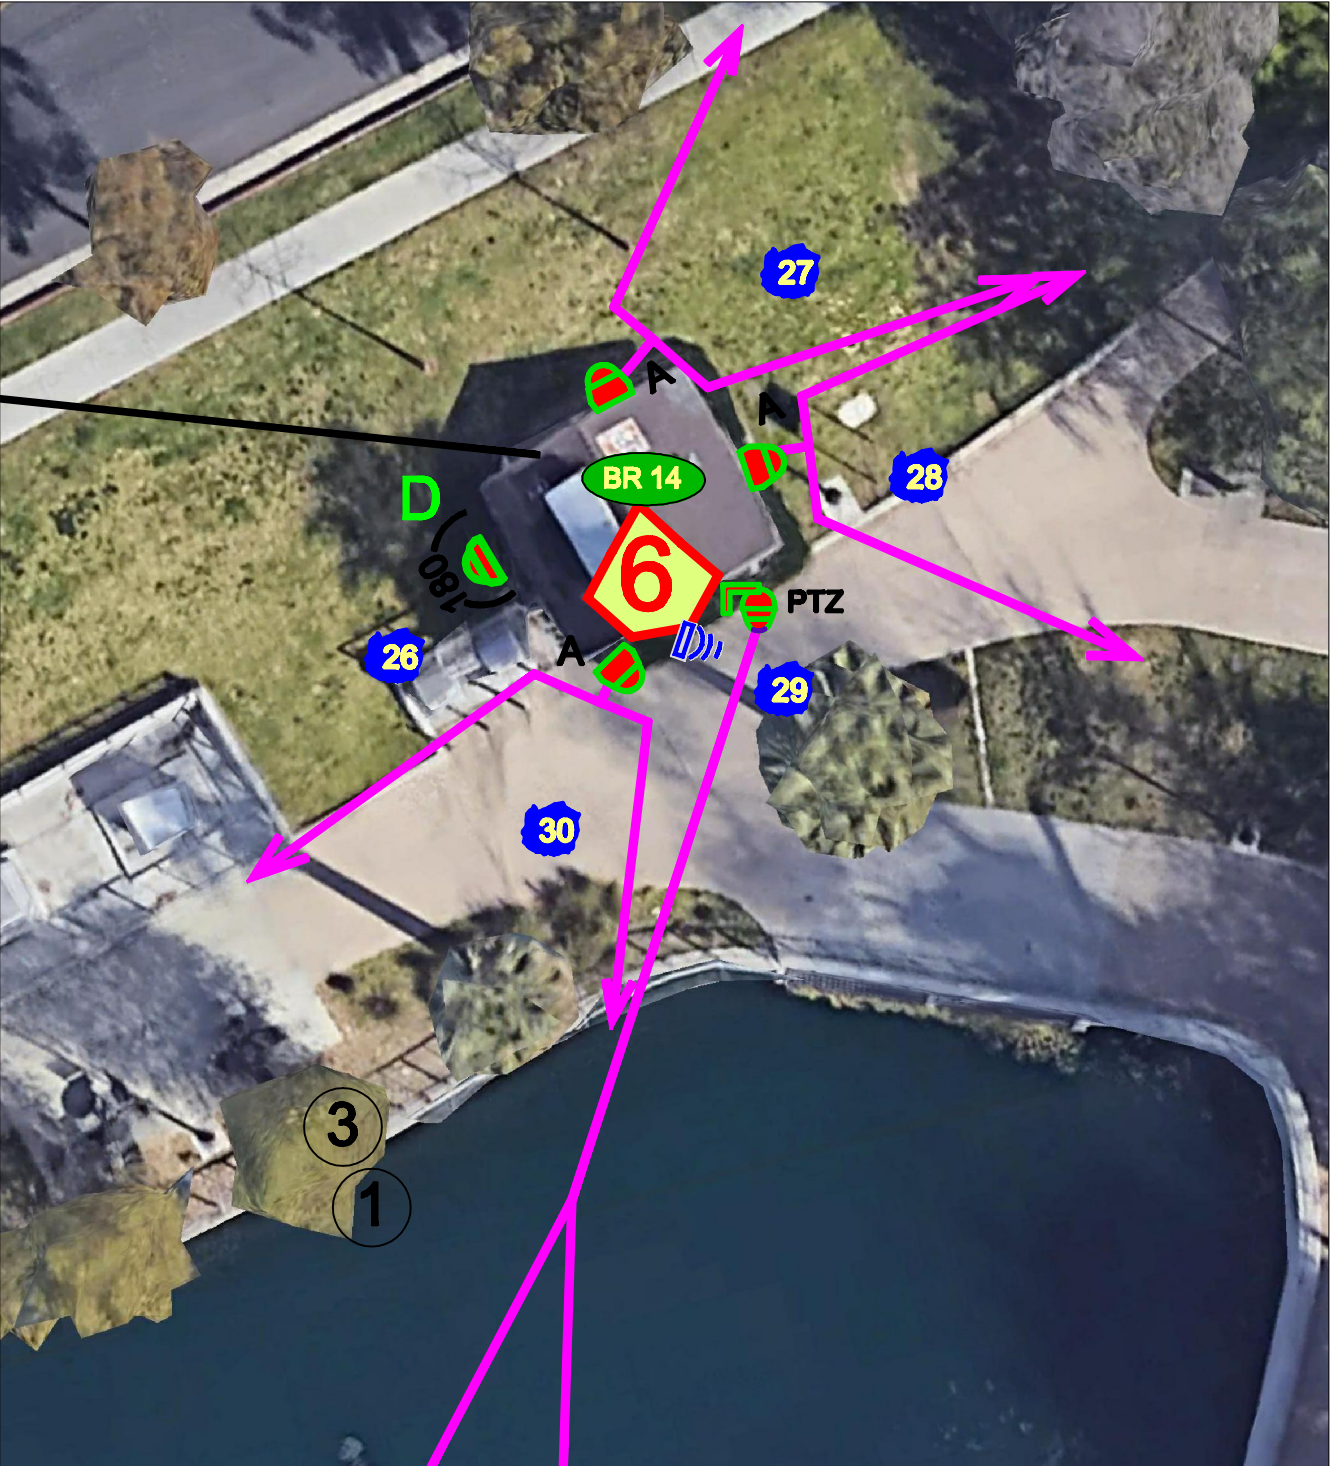

CCTV SITE PLAN NOTES:

- FOR ANTENNA MOUNTING SEE DETAIL #8 SHEET E-2593A - D1.
- NVR IN WALL CABINET. BACKBOX INSTALLED BY ELECTRICAL CONTRACTOR. 120V POWER REQUIRED. SEE DETAILS #1, #2, & #3 SHEET E-2598A-D1
- EQUIPMENBT CABINET ON OR IN BUILDING (120V AC REQUIRED). CANTEX BOX 18"X18"X 6" BY ELECTRICAL CONTRACTOR. MOUNTING LOCATIONS TO BE DETERMINED. SEE DETAILS #7 SHEET E-2598A - D1
- CAMERA MOUNTING ON OUTSIDE OF BUILDING SEE DETAILS #11 SHEET E-2598A - D1
- ELECTRICAL CONTRACTOR TO PROVIDE PULL STRING IN ALL CONDUIT.
- ALL LOCATIONS TO BE VERIFIED BEFORE INSTALLATION
- POE SWITCH 24 PORT REQUIRED W/(1) QUAD 120V OUTLET BY ELECTRICAL. THE EQUIPMENT CABINET FOR THIS BUILDING IS 24"X18"X8" BY ELECTRICAL. LOCATION AND PATH WAY TO BE DETERMINED DURING THE JOB WALK.
- CAMERAS AND EXPOSED CONDUIT ON RECREATION CENTER EXTERIOR TO BE PAINTED TO MATCH BUILDING COLOR.
- WALL MOUNTED MONITOR. 120V POWER REQUIRED. SEE DETAILS #9 SHEET E-2598A - D1

1 SITE CCTV PLAN
SCALE: NONE

RECREATION CENTER

RESTROOM SOUTH

- CAMERA NUMBER
- AP # = AP NUMBER
2 THRU 10 ACCESS POINT
- BR # = BRIDGE NUMBER
11 THRU 90 WIRELESS BRIDGE

1520 W. 178th Street
Gardena, Ca 90248
Phone
(310) 756-6610
Fax
(888) 251-1218
State License No. 986306

PROJECT NAME:

ECHO PARK (LAKE)
751 ECHO PARK AVE
LOS ANGELES, CA. 90026

SHEET TITLE:
CAMERA SYSTEM LAYOUT
SOUTH END

PAGE 2 OF 3

DESIGNED BY A.N., E.G.	APPROVED BY	JOB NO. J —	DATE: 5/5/2021
DRAWN BY A. NIE	APPROVED BY	SCALE:	
CHECKED BY ED	APPROVED BY	DRAWING NO. E-2598A-S2	REV. NO.
SUPERVISOR JOHN	APPROVED BY CONNER		